

# BULLETIN # 0 9

**DATE:** June 6, 2025

**TO:** Piazza Inc.  
Attn: Gus Carvajal

**CC:** Jordan Medina, Hill Intl.,

**FROM:** Brian Dunn, AIA  
KG+D Architects, PC

**PROJECT:** Harrison Recreation & Community Center – PHASE 2  
Harrison, NY

**RE:** Remove Air Purifiers




## Message:

Please provide credit pricing for the removal of the air purifiers as shown on M201, M202, M203, M204, and M603, as they are not required for the project.

### **KG+D Architects, PC**

285 Main Street, Mount Kisco, New York 10549  
914.666.5900 [kgdarchitects.com](http://kgdarchitects.com)

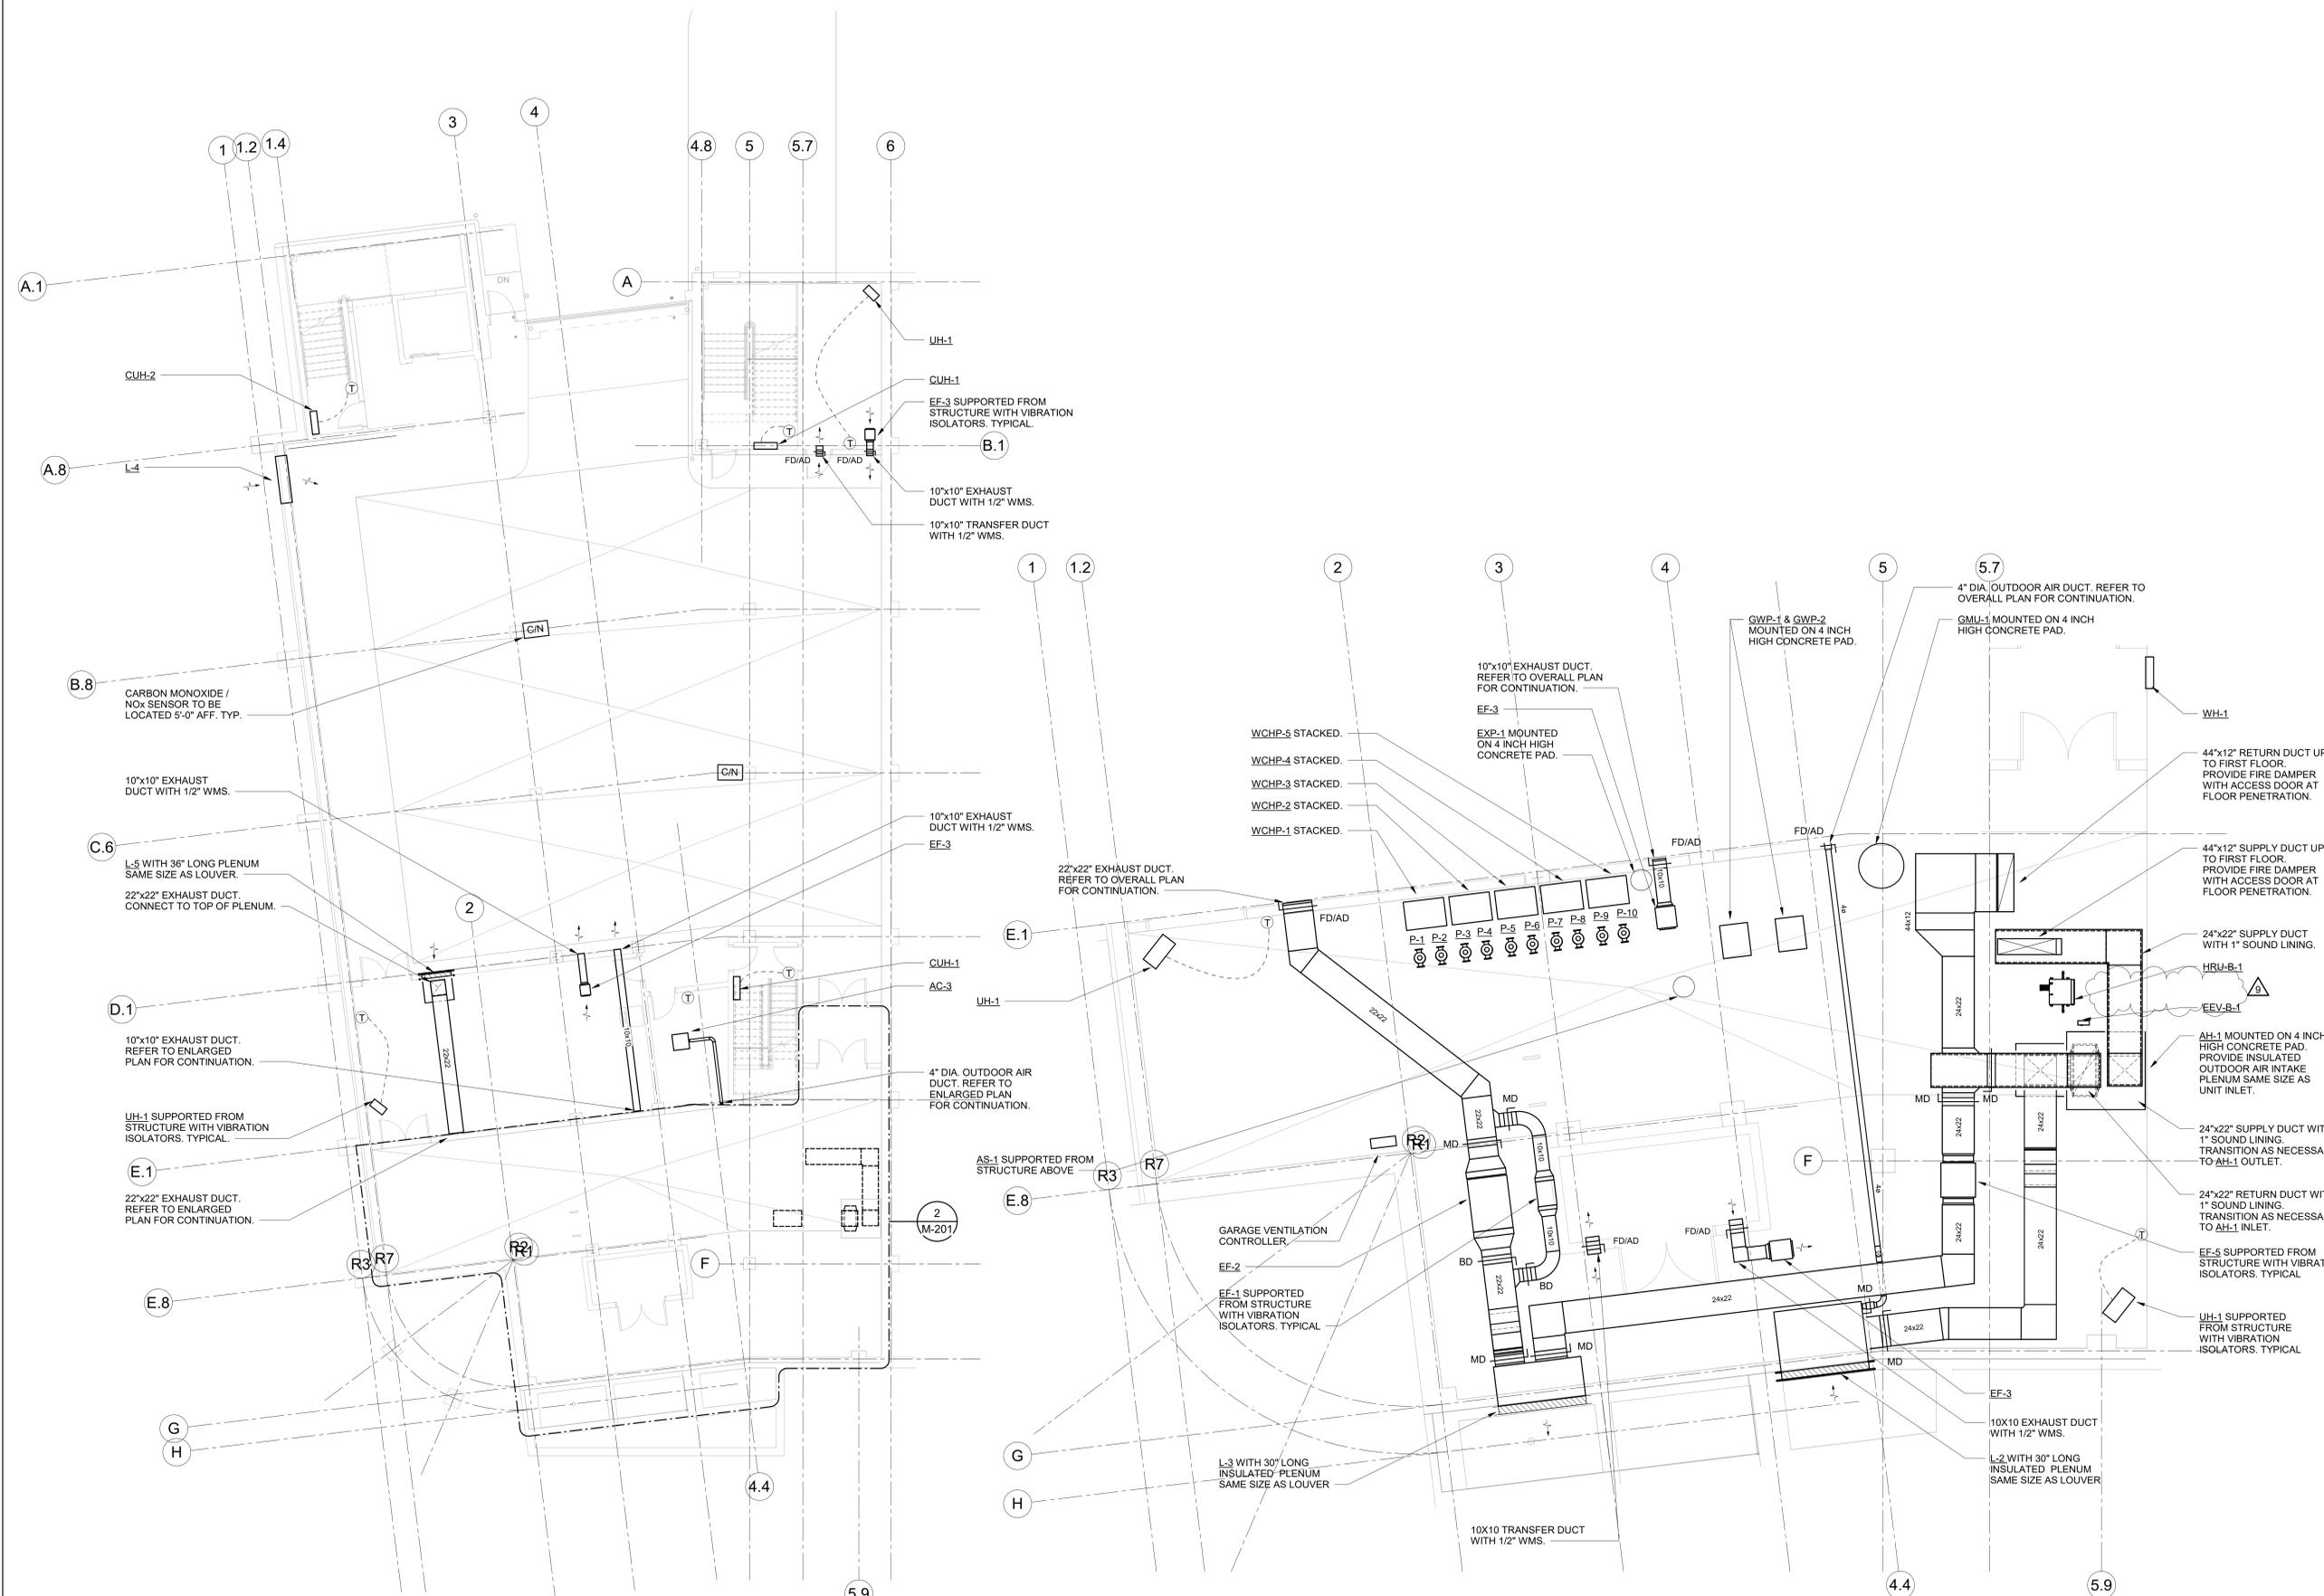

**1 MECHANICAL PARKING FLOOR PLAN**  
 SCALE: 1/8" = 1'-0"  
 NOTES:  
 1. ALL WALL MOUNTED GRILLES SHALL BE MOUNTED ONE CMU BLOCK ABOVE DOOR. CONTRACTOR SHALL COORDINATE LOCATION WITH FINAL CMU BLOCK LAYOUT.

**2 MECH B06 ENLARGED PLAN**  
 SCALE: 1/4" = 1'-0"  
 NOTES:  
 1. ROUTE ALL DUCTWORK AND PIPING AS HIGH AS POSSIBLE

Key Plan

NOTE: ALL IDEAL, DESIGN, ARRANGEMENTS AND PLANS INDICATED OR REPRESENTED BY THIS DRAWING ARE OWNED BY AND ARE THE PROPERTY OF HARRISON GARDEN & HOME ARCHITECTS, PC (HGA). HGA HEREBY GRANTS FOR USE ON THIS PROJECT. NONE OF SUCH IDEAL, DESIGN, ARRANGEMENTS OR PLANS SHALL BE USED BY OR DISCLOSED TO ANY PERSON WHATSOEVER WITHOUT THE WRITTEN PERMISSION OF HGA.  
 WRITTEN DIMENSIONS ON THIS DRAWING SHALL HAVE PRECEDENCE OVER SCALE DIMENSIONS. CONTRACTOR SHALL VERIFY ALL ACTUAL DIMENSIONS AND CONDITIONS ON THE JOB AND THE ARCHITECT MUST BE NOTIFIED OF ANY VARIATIONS FROM DIMENSIONS AND CONDITIONS BEFORE PROCEEDING WITH FABRICATION.  
 ALTERATIONS BY ANY PERSON IN ANY WAY OF ANY ITEM CONTAINED ON THIS DOCUMENT, UNLESS ACTING UNDER THE DIRECTION OF THE LICENSED ARCHITECT WHOSE PROFESSIONAL SEAL IS AFFIXED HERETO, IS A VIOLATION OF TITLE 16, SECT. 89.3 (a) OF NEW YORK STATE LAW.  
 COPYRIGHT © 2024, HARRISON GARDEN & HOME ARCHITECTS & ENGINEERS, PC. ALL RIGHTS RESERVED.

Professional Seal

No.	Date	Issue
9	05/29/2025	BULLETIN 8
8	10/09/2024	ISSUED FOR CONSTRUCTION
7	10/09/2024	CONFIRMED SET
6	07/01/2024	BID ADDENDUM #2
4	06/05/2024	ISSUED FOR BID
3	01/16/2024	ISSUED FOR PERMIT
2	09/01/2020	DESIGN DEVELOPMENT
1	03/12/2020	50% DESIGN DEVELOPMENT

Sheet Title


**MECHANICAL PARKING FLOOR PLAN**

Job No. NKGD0207.00 Date 02/16/2024  
 Scale AS NOTED Drawn / Checked HM / RG  
 Sheet Number **M-201**

9	05/28/2025	BULLETIN 8
8	10/09/2024	ISSUED FOR CONSTRUCTION
7	10/09/2024	CONFORMED SET
4	06/05/2024	ISSUED FOR BID
3	01/16/2024	ISSUED FOR PERMIT
2	09/01/2020	DESIGN DEVELOPMENT
1	03/12/2020	50% DESIGN DEVELOPMENT

**MECHANICAL FIRST FLOOR PLAN**

Job No.	NKGD0207.00	Date	02/16/2024
Scale	AS NOTED	Drawn / Checked	HM / RG
Sheet Number	M-202		

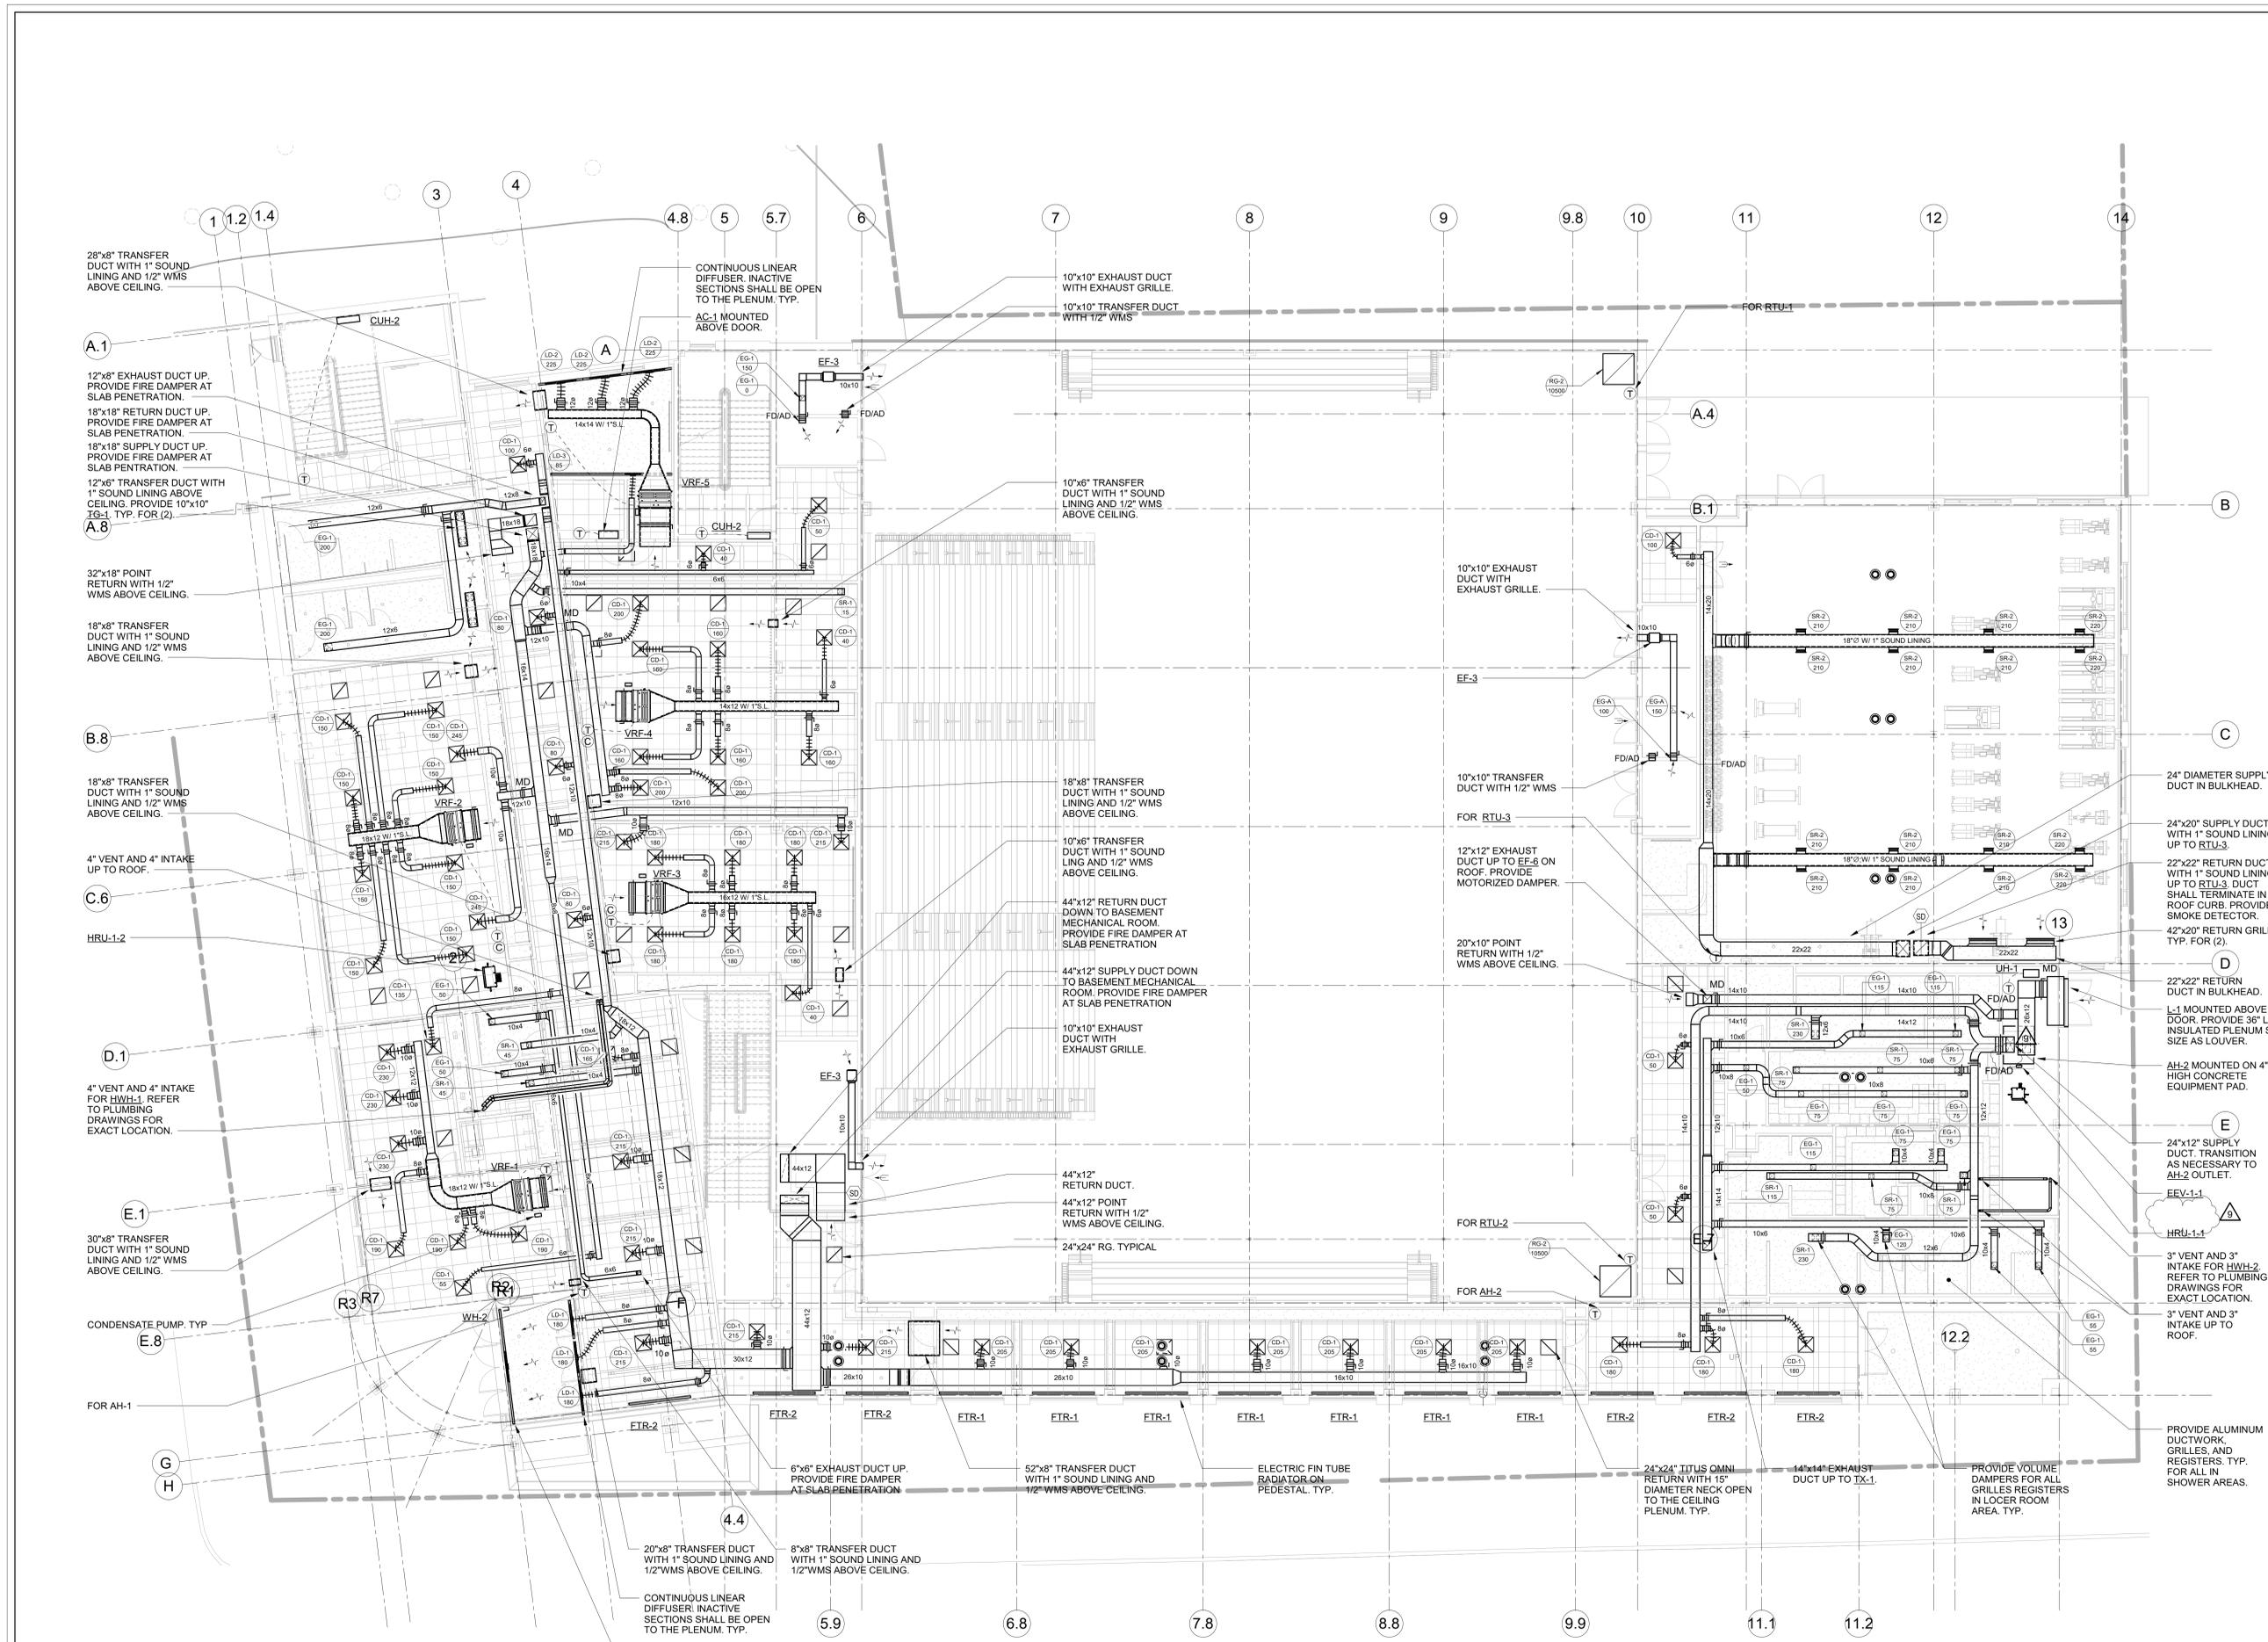

**MECHANICAL FIRST FLOOR PLAN**


SCALE: 1/8" = 1'-0"

- NOTES:
- DUCTED VRF INDOOR UNITS: PROVIDE 24" DEEP, ACOUSTICALLY LINED, FULL SIZED RETURN AIR DUCT AT RETURN AIR CONNECTION WITH FILTER BANK AND VOLUME OR MOTORIZED DAMPER WHERE CALLED OUT.
  - PROVIDE 'YOUNG' REGULATOR VOLUME DAMPERS IN ALL HARD CEILING AREAS FOR BALANCING PURPOSES.
  - ALL VRF UNITS SHALL BE HUNG FROM STRUCTURE ABOVE. PROVIDE VIBRATION ISOLATORS.
  - ALL WALL MOUNTED GRILLES SHALL BE MOUNTED ONE CMU BLOCK ABOVE DOOR. CONTRACTOR SHALL COORDINATE LOCATION WITH FINAL CMU BLOCK LAYOUT.

No.	Date	Issue
9	05/29/2025	BULLETIN 8
8	10/09/2024	ISSUED FOR CONSTRUCTION
7	10/09/2024	CONFIRMED SET
6	07/10/2024	BID ADDENDUM #2
4	06/05/2024	ISSUED FOR BID
3	01/16/2024	ISSUED FOR PERMIT
2	09/01/2023	DESIGN DEVELOPMENT
1	03/13/2020	50% DESIGN DEVELOPMENT

**MECHANICAL  
SECOND FLOOR  
PLAN**

Job No.	NKGD0207.00	Date	02/16/2024
Scale	AS NOTED	Drawn / Checked	HM / RG
Sheet Number	<b>M-203</b>		

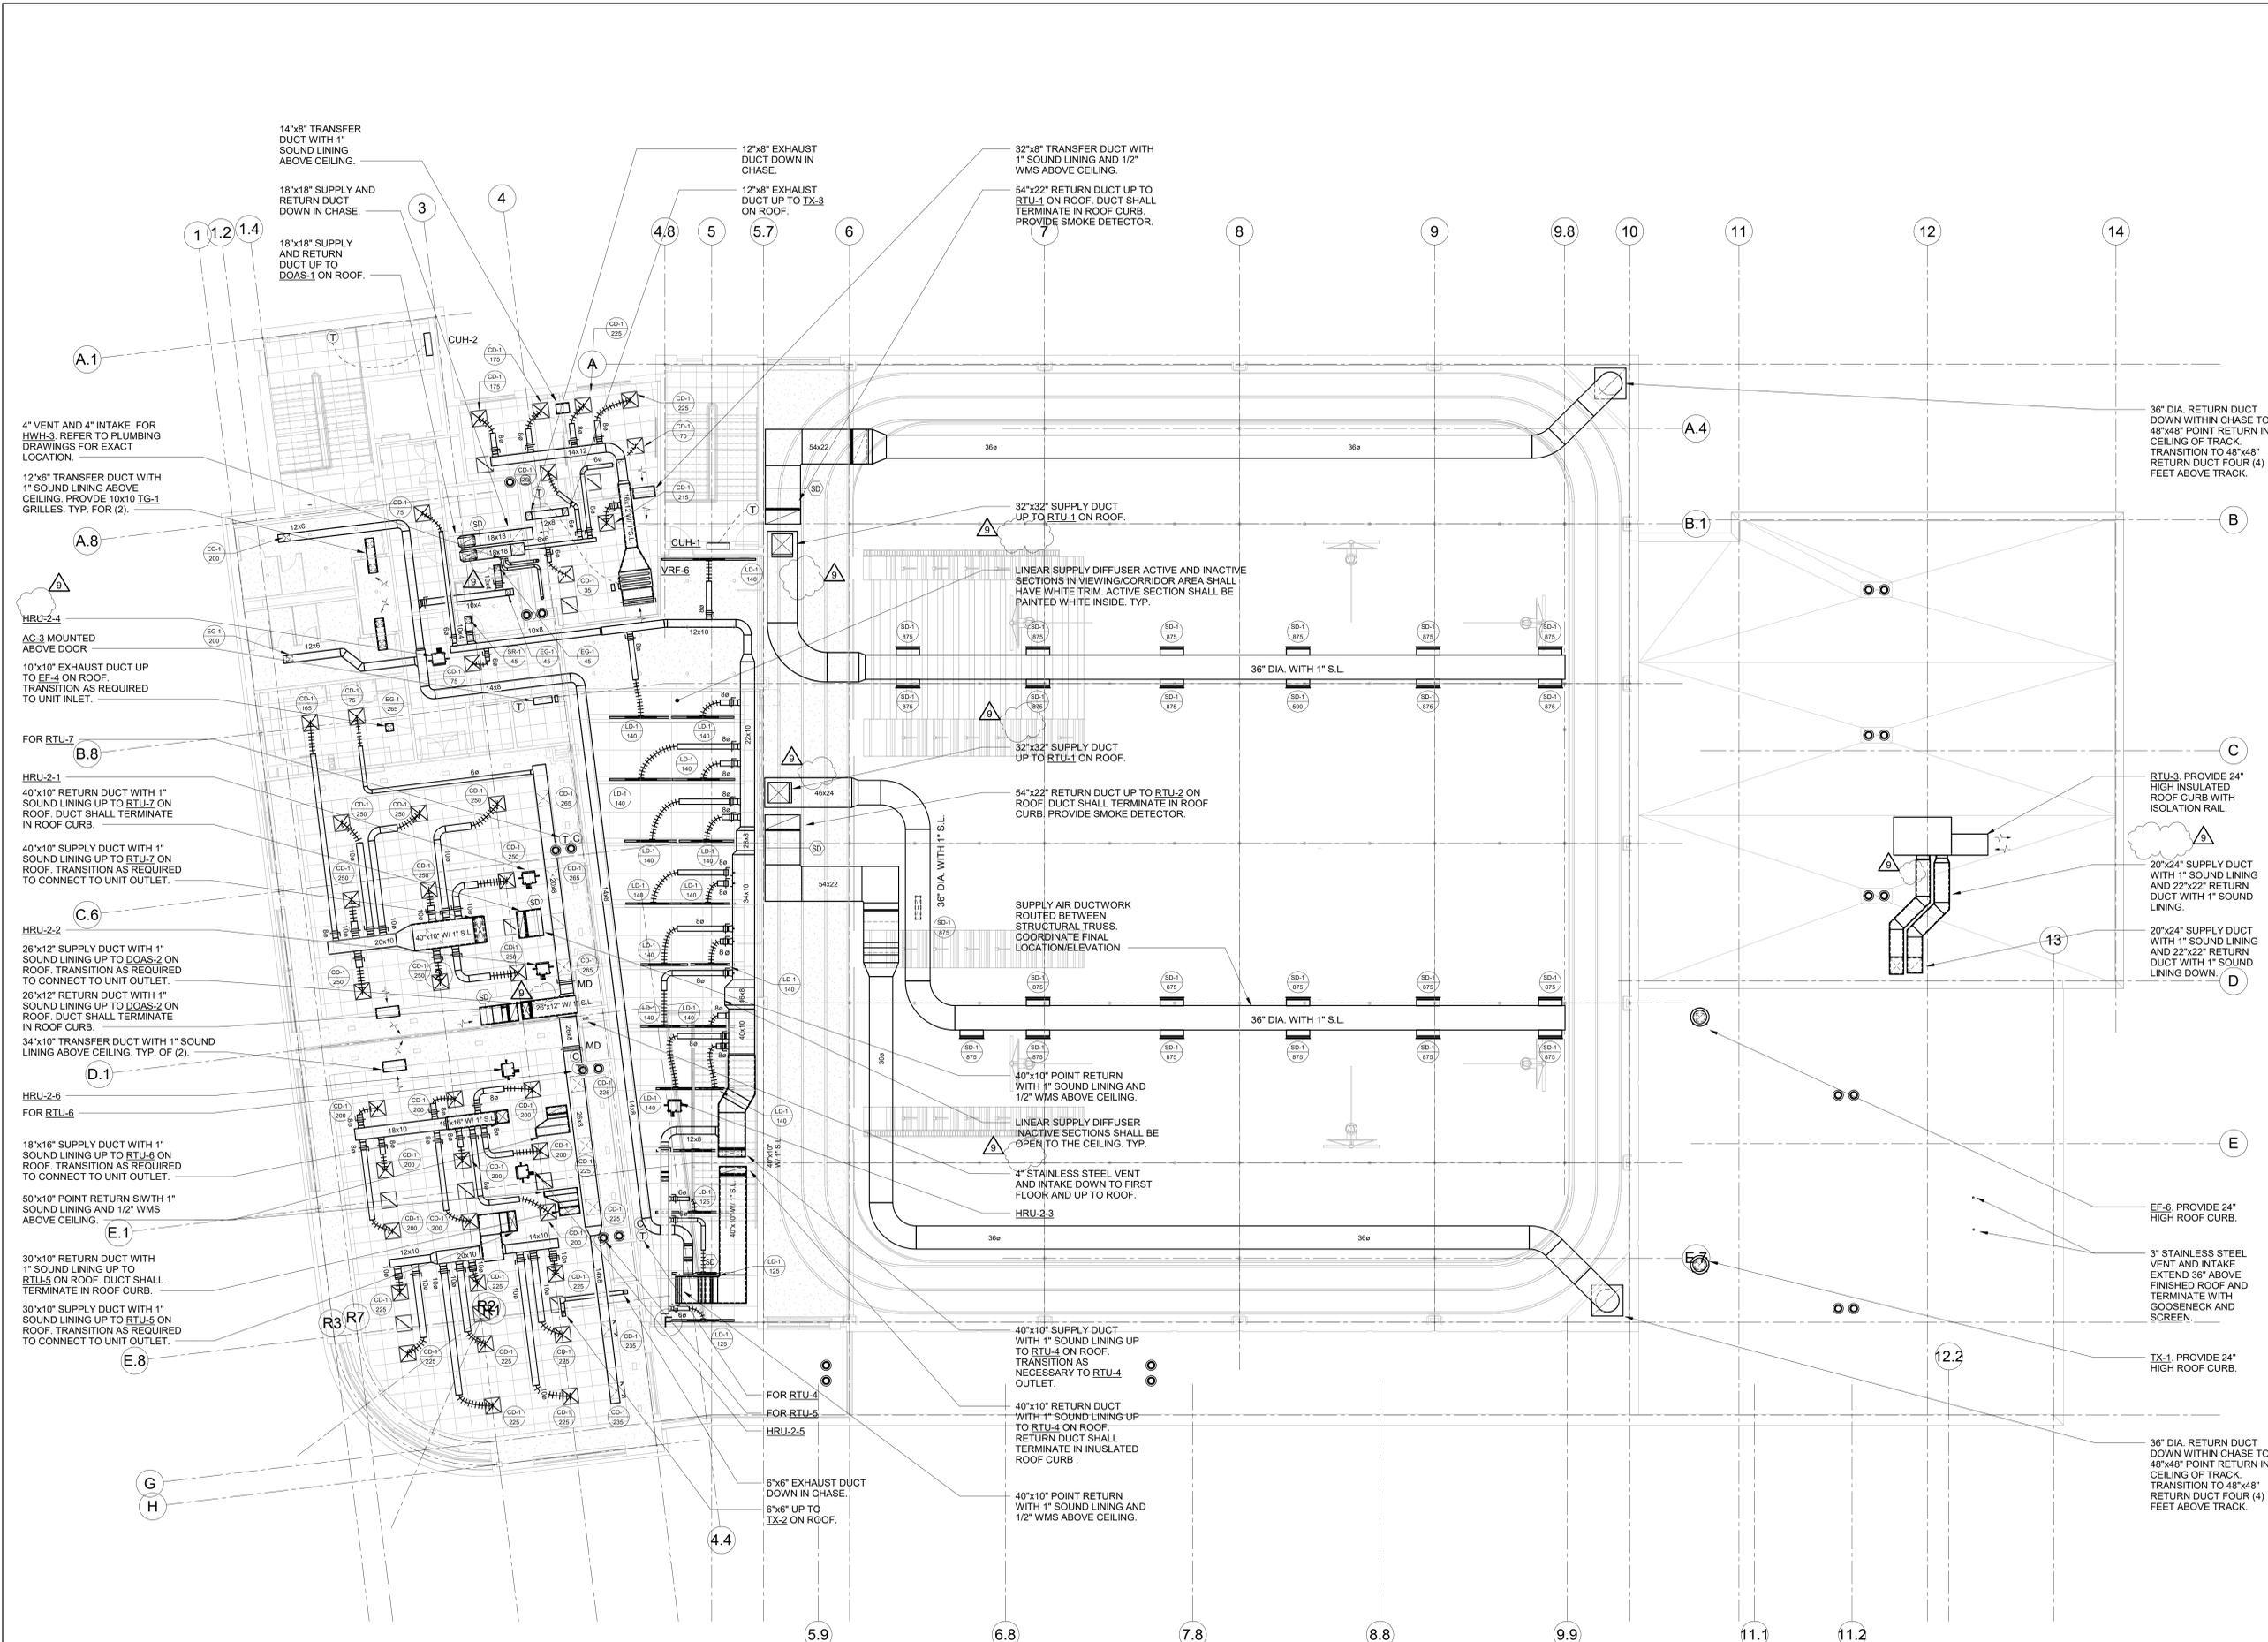

**MECHANICAL SECOND FLOOR PLAN**

SCALE: 1/8" = 1'-0"

- NOTES:
- DUCTED VRF INDOOR UNITS: PROVIDE 24" DEEP, ACOUSTICALLY LINED, FULL SCALE RETURN AIR DUCT AT RETURN AIR CONNECTION WITH FILTER BANK AND VOLUME OR MOTORIZED DAMPER WHERE CALLED OUT.
  - PROVIDE 'YOUNG' REGULATOR VOLUME DAMPERS IN ALL HARD CEILING AREAS FOR BALANCING PURPOSES.
  - ALL VRF UNITS SHALL BE HUNG FROM STRUCTURE ABOVE. PROVIDE VIBRATION ISOLATORS

**HARRISON  
RECREATION &  
COMMUNITY  
CENTER**

New Construction - Phase 2  
Town / Village of Harrison  
270 Harrison Avenue  
Harrison, NY 10528



**CONSTRUCTION DOCUMENTS**

Key Plan

NOTE: ALL IDEAS, DESIGN ARRANGEMENTS AND PLANS INDICATED OR REPRESENTED BY THIS DRAWING ARE OWNED BY AND ARE THE PROPERTY OF HARRISON RECREATION & COMMUNITY CENTER ARCHITECTS, PC (HRC). NO PART OF THIS DRAWING OR ANY INFORMATION CONTAINED HEREIN SHALL BE REPRODUCED OR TRANSMITTED IN ANY FORM OR BY ANY MEANS, ELECTRONIC OR MECHANICAL, INCLUDING PHOTOCOPYING, RECORDING, OR BY ANY INFORMATION STORAGE AND RETRIEVAL SYSTEM, WITHOUT THE WRITTEN PERMISSION OF HRC.

WRITTEN DIMENSIONS ON THIS DRAWING SHALL HAVE PRECEDENCE OVER SCALE DIMENSIONS. CONTRACTOR SHALL VERIFY ALL ACTUAL DIMENSIONS AND CONDITIONS ON THE JOB AND THE ARCHITECT MUST BE NOTIFIED OF ANY VARIATIONS FROM DIMENSIONS AND CONDITIONS SHOWN. SHOP DETAILS MUST BE SUBMITTED TO THIS OFFICE FOR APPROVAL BEFORE PROCEEDING WITH FABRICATION.

ALTERATIONS BY ANY PERSON IN ANY WAY OF ANY ITEM CONTAINED ON THIS DOCUMENT, UNLESS ACTING UNDER THE DIRECTION OF THE LICENSED ARCHITECT WHOSE PROFESSIONAL SEAL IS ATTACHED HERETO, IS A VIOLATION OF TITLE 16, SECTION 201.1 OF THE NEW YORK STATE LAW. COPYRIGHT © 2024, HARRISON RECREATION & COMMUNITY CENTER ARCHITECTS, PC. ALL RIGHTS RESERVED.

Professional Seal

No.	Date	Issue
9	05/29/2025	BULLETIN 8
8	10/09/2024	ISSUED FOR CONSTRUCTION
7	10/09/2024	CONFIRMED SET
6	07/10/2024	BID ADDENDUM #2
4	06/05/2024	ISSUED FOR BID
3	01/16/2024	ISSUED FOR PERMIT
2	09/01/2023	DESIGN DEVELOPMENT
1	03/12/2020	50% DESIGN DEVELOPMENT


Sheet Title

**MECHANICAL  
ROOF PLAN**

Job No.	Date
NKGD0207.00	02/16/2024
Scale	Drawn / Checked
AS NOTED	HM / RG

Sheet Number

**M-204**

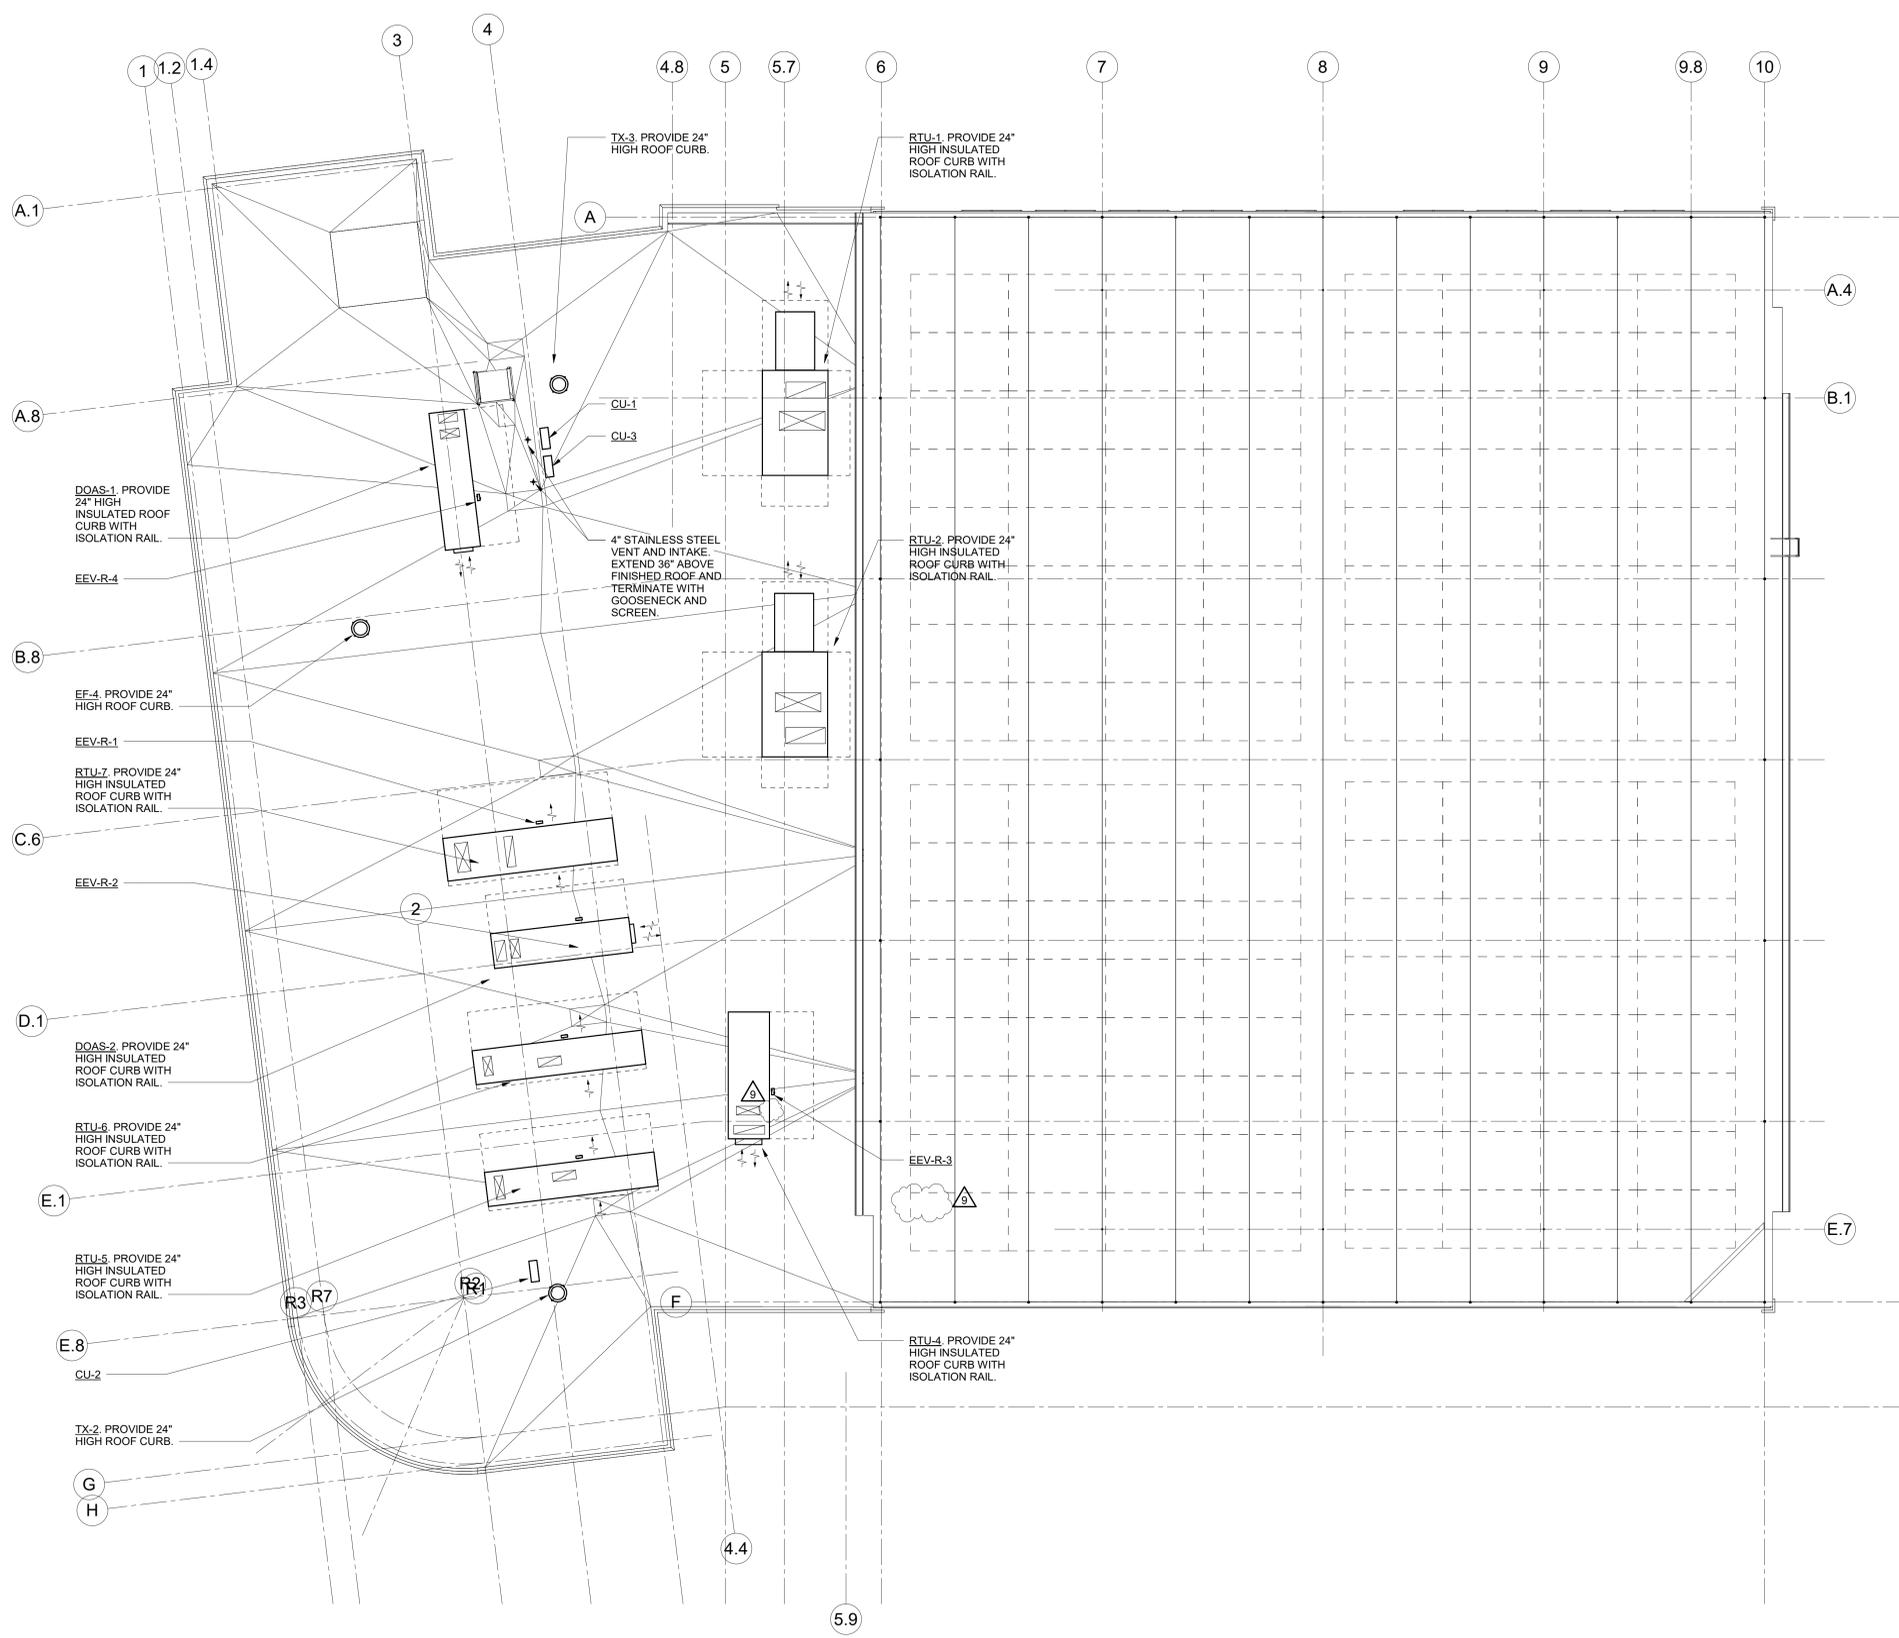

**MECHANICAL ROOF PLAN**  
SCALE: 1/8" = 1'-0"

